




**ROOF FRAMING PLAN**  
SCALE: 1/4" = 1'-0"

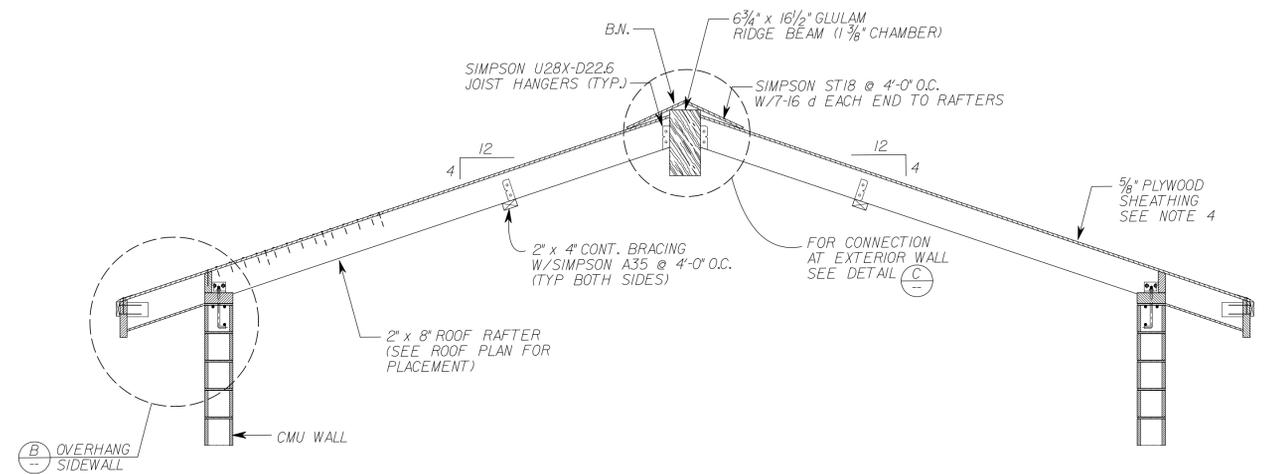


**PUMP ROOM SECTION A**  
SCALE: 1/2" = 1'-0"

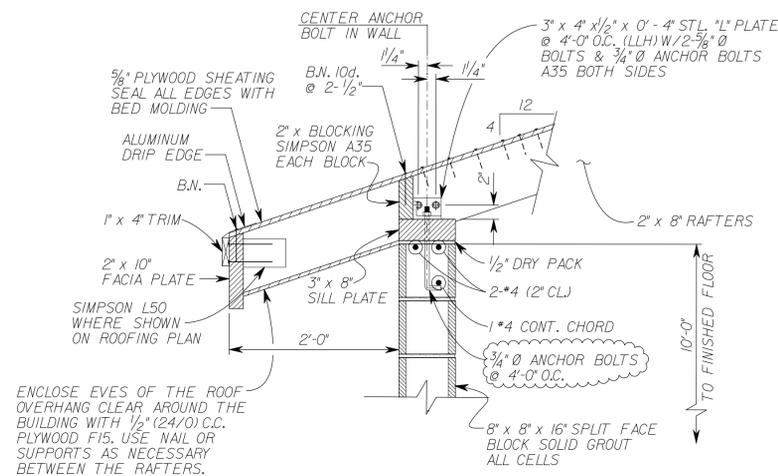

**OVERHANG SIDEWALL SECTION B**  
SCALE: 1" = 1'-0"

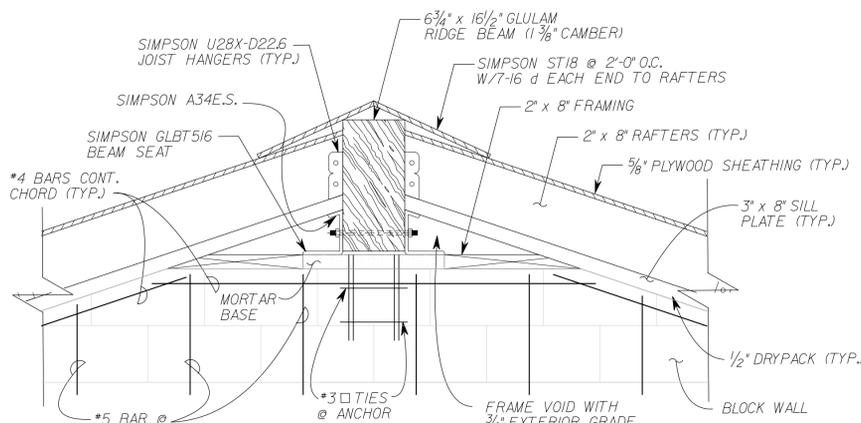

**RIDGE BEAM EXTERIOR WALL SECTION C**  
SCALE: 1" = 1'-0"

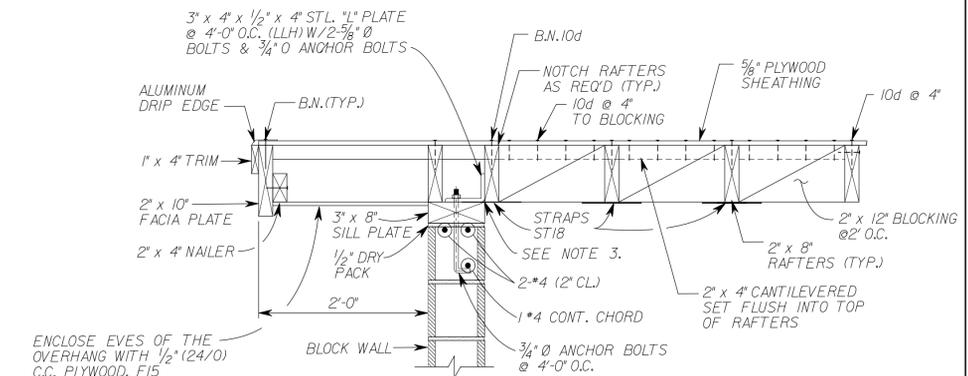

**OVERHANG ENDWALL SECTION D**  
SCALE: 1" = 1'-0"

**NOTES:**

- ON THE INTERIOR OF THE WALL, THE CONTRACTOR SHALL PLACE 3/4" INTERIOR GRADE PLYWOOD TO COVER THE VOIDS BETWEEN THE FRAMING AND ANY REMAINING MASONRY OPENINGS.
- ON THE EXTERIOR SIDE OF THE WALL, THE CONTRACTOR SHALL PLACE 3/4" EXTERIOR GRADE PLYWOOD TO COVER THE VOIDS BETWEEN THE FRAMING AND ANY REMAINING MASONRY OPENINGS.
- CONNECT THE STRAP TO WOOD PLATE AND BLOCKING BY NAIL.
- ROOF SHEATHING SHALL BE STRUCTURAL I GRADE PLYWOOD, BLOCK ALL EDGES, 10d @ 4' OC B.N., 10d 4' EN., AND 10d @ 12' FN.

AKM JOB No. 0760890.00

Underground Service Alert

Call: TOLL FREE



TWO WORKING DAYS BEFORE YOU DIG

0	1/2	1	24x36 FORMAT IF THIS BAR MEASURES 1" THEN DRAWING SCALE IS AS NOTED
0	1/4	1/2	12x18 FORMAT WARNING IF THIS BAR MEASURES 1/2" THEN DRAWING IS NOT FULL SCALE AND IS 50% REDUCED

Designed by KEVIN SALEH	Drawn by CADD	Checked by GARY J. HOBSON
PLANS PREPARED UNDER SUPERVISION OF GARY J. HOBSON		
Date MARCH 2010	R.C.E. No. 40779	



AKM CONSULTING ENGINEERS  
553 WALD  
IRVINE, CA. 92618  
(949) 753-7333

CDWP	Department of Water and Power Approval
WMWD	By Donald A. Williams, P.E. R.C.E. No. 32333 EXP 12/31/2010

Approved	By Jeffrey D. Sims, P.E. R.C.E. No. 48212, Exp. 12/31/10 Assistant General Manager/ Chief Operations Officer
----------	--

Approved	By Kip D. Field, P.E. R.C.E. No. 45679, Exp. 12/31/10 Public Works Director
----------	--

CITY OF CORONA - ARLINGTON DESALTER CONNECTION	Drawing No. 09-050U
WESTERN MUNICIPAL WATER DISTRICT - PROMENADE CONNECTION	S-3
ROOF FRAMING PLAN AND DETAILS	Sht. 12 of 24

