


PLOT DATE: 2/19/2010 PLOT TIME: 10:55:06 AM

NDM-SCO-EMWD USACE PERRIS II/ PDF 0105.d.dgn

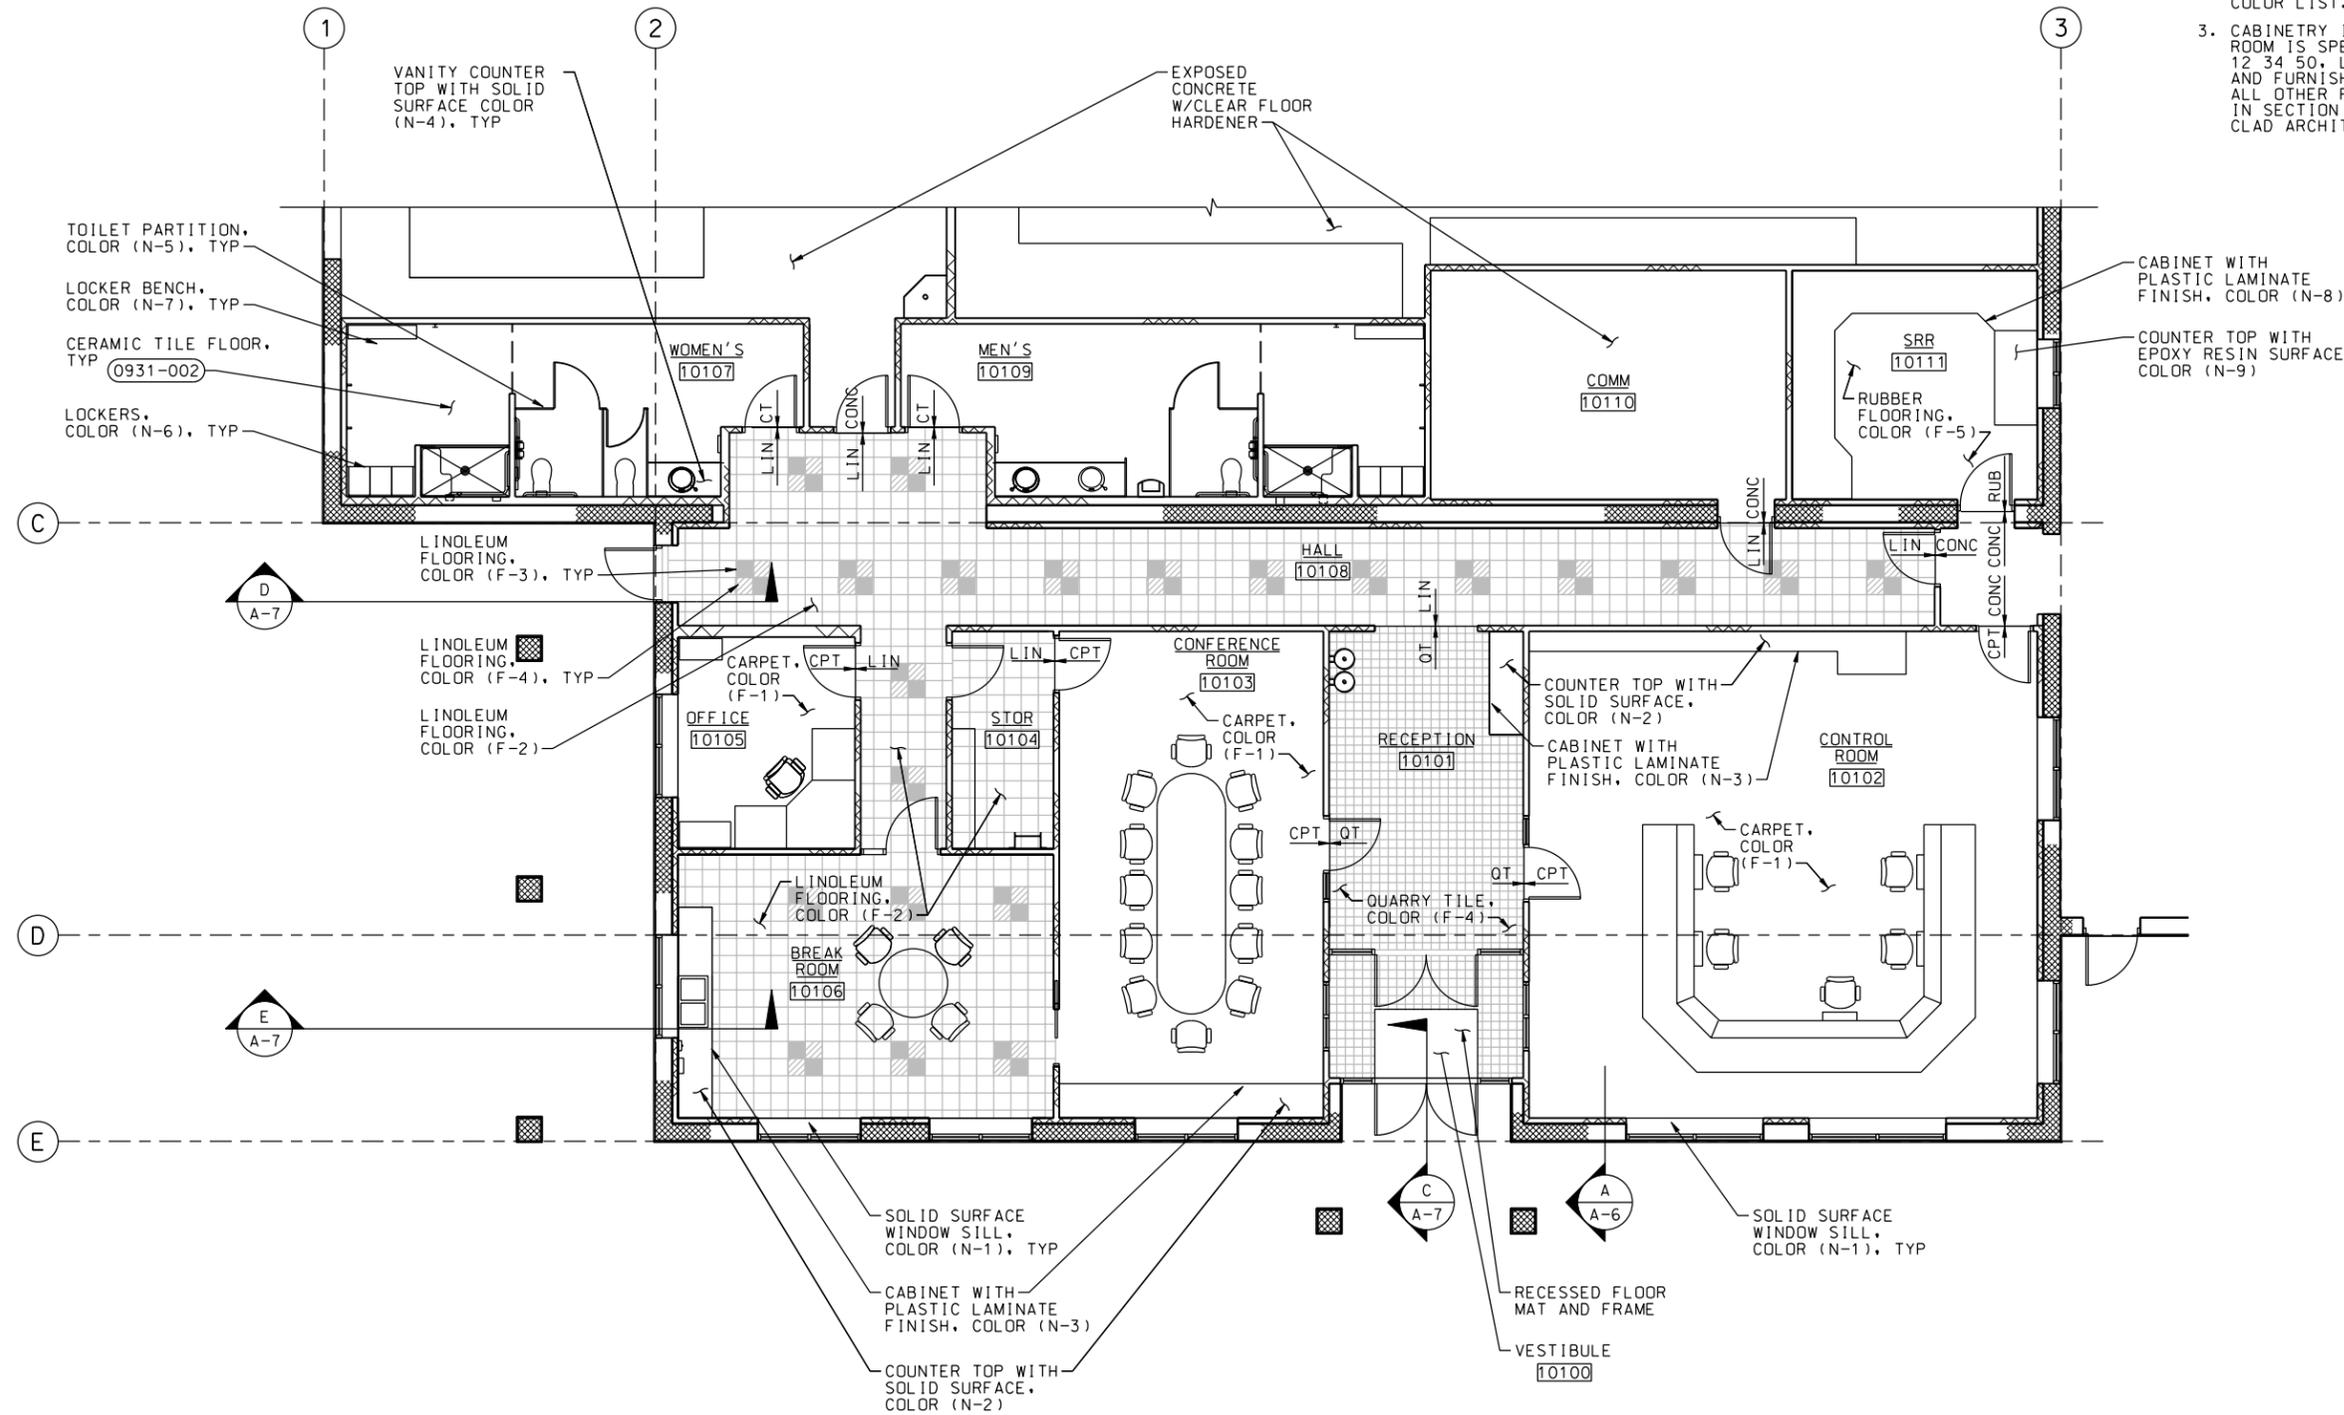

NOTES:

- FOR GENERAL ARCHITECTURAL NOTES, SYMBOLS, LEGEND AND WALL TYPES SEE DWG G-7.
- REFER TO DWG'S A-24 AND A-25 FOR FINISH SCHEDULES AND COLOR LIST.
- CABINETS IN SAMPLE RECEIVING ROOM IS SPECIFIED IN SECTION 12 34 50, LABORATORY CASEWORK AND FURNISHINGS. CABINETS IN ALL OTHER ROOMS IS SPECIFIED IN SECTION 06 41 16, LAMINATE CLAD ARCHITECTURAL CASEWORK.

EASTERN MUNICIPAL WATER DISTRICT
PERRIS II DESALINATION FACILITY
PERRIS, CALIFORNIA

ADMIN AREA
PARTIAL FINISH FLOOR PLAN

DESIGNED BY: G. KRISTEN
DRAWN BY: A. VARGAS
CHECKED BY: S. FRESN

U.S. ARMY ENGINEER DISTRICT
LOS ANGELES
CORPS OF ENGINEERS

CH2MHILL
SUBMITTED BY:
ART. JUNG, P.E.
CHIEF, DESIGN BRANCH

SHEET
A-5 40 OF 226
SHEETS

L.A. DISTRICT FILE NO. XXX-XXXX
SPEC. NO. : NOT APPLICABLE
CADD FILE NAME: PDF0105.dgn

SYMBOL	DESCRIPTIONS	REVISIONS	DATE	APPROVAL



DATE: 10/05/09

ADMIN AREA PARTIAL FINISH FLOOR PLAN
3/16"=1'-0"